

The New Additions And Renovations For: Mid America Technology Center



BIDDING DOCUMENTS

Owner



Mid America Technology Center
27438 Oklahoma 59
Wayne, OK 73095

MATC SUPERINTENDENT
Mike Eubank, M.ED., NBCT Superintendent

MATC BOARD MEMBERS
Donna Stokes
Joe Ray
Mike Hancock
Doyle Greteman
Michael Dillinger

Consultants

STRUCTURAL
KFC Engineering P.C.
205 N.W. 63, Suite 390
Oklahoma City, OK 73116

MECHANICAL AND PLUMBING
Allen Consulting Inc.
115 W Main St.
Norman, Oklahoma 73069

ELECTRICAL
Allen Consulting Inc.
115 W Main St.
Norman, Oklahoma 73069

ARCHITECT OF RECORD



Design Architects Plus, Inc.
1501 S.W. 104th
Oklahoma City, OK 73159
Phone No. (405)691-9900
Fax. No. (405)691-2080
www.dap-okc.com

The 2022 New Additions and Renovations For: Mid America Technology Center

27438 Oklahoma 59

Wayne, Oklahoma 73095

ABBREVIATIONS

AC	ACOUSTIC	LAM	LAMINATED
AD	AREA DRAIN	LG	LONG
ADJ	ADJUSTABLE	LP	LOW POINT
AFF	ABOVE FINISH FLOOR	LAV.	LAVATORY
ALT	ALTERNATE	MANUF	MANUFACTURER
ALUM	ALUMINUM	MAS	MASONRY
ANOD	ANODIC ANODIZED	MAT	MATERIAL
L	ANGLE	MAX	MAXIMUM
AUX	AUXILIARY	MECH	MECHANICAL
A/C	AIR CONDITIONED	MTD	MOUNTED
A.B.	ANCHOR BOLT	MTL	METAL
A. DR.	ACCESS DOOR	MIN	MINIMUM
AB. FL	ABOVE FLOOR	MTD.	MOUNTED
BIT	BITUMINOUS	M	MISCELLANEOUS
BO	BOND	MISC.	MISCELLANEOUS
BLK'G	BLOCKING	NIC	NOT IN CONTRACT
BRZ	BRONZE	NTS	NOT TO SCALE
BLDG	BUILDING	NO.	NUMBER
BU	BUILT UP ROOF	OFF.	OFFICE
BV	BRICK VENT	O.H.D	OVER HEAD DOOR
BOTT	BOTTOM	OC	ON CENTER
BSMT	BASEMENT	OD	OUT SIDE DIAMETER
BRG.	BEARING	OPNG	OPENING
B.M.	BENCH MARK	OH, OPP HD	OPPOSITE HAND
CAB	CABINET	OVHD	OVERHEAD
CB	CATCH BASIN	PR	PAIR
CEM	CEMENT	PARTN	PARTITION
C.T.	CERAMIC TILE	>	PLATE
CLG	CEILING	POL GL	POLISHED PLATE GLASS
<	CENTER LINE	PLAS	PLASTER
C	CHANNEL	POL	POLISHED
CLOS	CLOSET	PORC EN	PORCELAIN ENAMEL
COL	COLUMN	PSI	POUNDS PER SQUARE INCH
C.M.U.	CONCRETE MASONRY UNIT	PROJ	PROJECTION
COMP	COMPRESSIBLE	PT	POINT
CONC	CONCRETE	PTD	PAINTED
CONST	CONSTRUCTION	PSF	POUNDS PER SQUARE FOOT
CORR	CORRIDOR	PLBG.	PLUMBING
CJ	CONTROL JOINT	PUB.	PUBLIC
CSL	CONTROL SLAB	QT	QUARRY TILE
CRT	CENTER	REF.	REFRIGERATOR
CONF	CONFERENCE	RF	ROOF
CONT.	CONTINUOUS	R	RADIUS
CNTR	CENTER	RD	ROOF DRAIN
DEPR	DEPRESSION	RM	ROOM
DTL	DETAIL	~	ROUND/DIAMETER
DF	DRINKING FOUNTAIN	REINF	REINFORCING
DWG	DRAWING	REQ	REQUIRED
DW	DRYWALL	RWC	RAIN WATER CONDUCTOR
DK	DECK	REM	REMOVABLE MULLION
DN	DOWN	REC	RECESSED
DBL	DOUBLE	RS	RELIEF SCUPPER
DIM	DIMENSION	RAD	RADIATION
EA	EACH	RET.	RETURN
EF	EXHAUST FAN	R/A	RETURN AIR
ELEV	ELEVATION	SHT	SHEET
ELEC	ELECTRIC	SIM	SIMILAR
EQ	EQUAL	S.S.	STAINLESS STEEL
EQUIP	EQUIPMENT	STL	STEEL
EJ	EXPANSION JOINT	STOR	STORAGE
EXIST	EXISTING	STRUCT. STR	STRUCTURAL
EXP	EXPANSION	SUSP	SUSPENDED
E.C.	ELECTRICAL CONTRACTOR	SLAB	SLAB
E.W.C.	ELECTRIC WATER COOLER	SECT.	SECTION
FTG.	FOOTING	SQ.	SQUARE
FON	FOUNDATION	STD.	STANDARD
FE	FIRE EXTINGUISHER	T	TILE
FEC	FIRE EXTINGUISHER CABINET	TEMP	TEMPERED
FIN	FINISH	TINT	TINTED
FLR	FLOOR	TOS	TOP OF SLAB
FD	FLOOR DRAIN	T&B	TOP AND BOTTOM
FLASH	FLASH	TRTD	TREATED
FTG	FOOTING	TYP	TYPICAL
FURN	FURNISH	T.O.W.	TOP OF WALL
FRPF	FIREPROOF, FIREPROOFING	TEL	TELEPHONE
GA	GUAGE	TH.	THICK
GC	GENERAL CONTRACTOR	T.	TOILET
GENL	GENERAL	U.C.	UNDER COUNTER
GL	GLASS	UNPOL	UNPOLISHED
GRP	GROUND	UV	UNIT VENTILATOR
GYP. BD	GYPSUM BOARD	URIN	URINAL
HDWD	HARDWOOD	VAC.	VACUUM
HM	HOLLOW METAL	VCT	VINYL COMPOSITION TILE
HP	HIGH POINT	VERT.	VERTICAL
HVAC	HEATING, VENTING, AND AIR CONDITIONING	W	WIDTH
HT	HEIGHT	W/	WITH
HC	HANDICAPPED	W/O	WITHOUT
HTR	HEATER	WD	WOOD
HORIZ	HORIZONTAL	W.GL	WIRE GLASS
HR.	HOUR	WIND	WINDOW
ID	INSIDE DIAMETER	WP	WATER PROOFING
INSUL	INSULATION	W.W.F / W.W.M.	WELDED WIRE MESH
INT.	INTERIOR	WSCOT.	WAINSCOT
JAN	JANITOR	W.C.	WATER CLOSET
JT	JOINT	WT.	WEIGHT
K.D.	KNOCK DOWN	WDW.	WINDOW

GENERAL

- G-1 COVER SHEET
- G-2 ADA INFORMATION SHEET
- G-3 CODE AND EGRESS PLAN

ARCHITECTURE

- A1.00 OVERALL SITE PLAN
- A1.01 DEMO SITE PLAN
- A1.02 SITE PLAN
- A1.03 DEMO FLOOR PLAN
- A2.00 OVERALL FLOOR PLAN
- A2.01 WEST FLOOR PLAN
- A2.02 EAST FLOOR PLAN
- A2.03 ENLARGED TOILE PLANS
- A2.04 TOILET ELEVATIONS
- A2.05 DOOR SCHEDULES
- A2.06 WINDOW SCHEDULES
- A2.07 HEAD, JAMB & SILL DETAILS
- A3.00 WEST ROOF PLAN
- A3.01 EAST ROOF PLAN
- A3.02 ROOF DETAILS
- A3.03 ROOF DETAILS
- A4.00 ELEVATIONS
- A4.01 ELEVATIONS
- A5.00 BUILDING SECTIONS
- A5.01 WALL SECTIONS
- A5.02 WALL SECTIONS
- A5.03 WALL SECTIONS
- A5.04 WALL SECTIONS
- A5.05 WALL SECTIONS
- A5.06 WALL SECTIONS
- A5.07 WALL SECTIONS
- A5.08 WALL SECTIONS
- A5.09 WALL SECTIONS
- A6.00 WALL TYPES
- A7.00 CASEWORK
- A7.01 CASEWORK SECTIONS
- A8.00 WEST REFLECTED CEILING PLAN
- A8.01 EAST REFLECTED CEILING PLAN
- A8.02 REFLECTED CEILING SECTIONS
- A8.03 REFLECTED CEILING SECTIONS
- A8.04 REFLECTED CEILING SECTIONS
- A9.00 WEST FINISH PLAN
- A9.01 EAST FINISH PLAN

STRUCTURAL

- S1.00 GENERAL NOTES
- S1.01 GENERAL NOTES
- S1.02 GENERAL NOTES
- S1.03 GENERAL NOTES
- S1.04 SPECIAL INSPECTIONS
- S1.05 TYPICAL FOUNDATION DETAILS
- S1.06 TYPICAL FOUNDATION DETAILS
- S1.10 TYPICAL STEEL DETAILS
- S1.11 TYPICAL STEEL JOIST DETAILS
- S1.12 LOAD DIAGRAMS
- S1.13 TYPICAL SHELTER DETAILS
- S1.14 TYPICAL SHELTER DETAILS
- S2.00 OVERALL DRILLED PIER PLAN
- S2.01 DRILLED PIER LAYOUT PLAN - WEST
- S2.02 DRILLED PIER LAYOUT PLAN - EAST
- S2.03 OVERALL FOUNDATION PLAN
- S2.04 PARTIAL FOUNDATION PLAN - WEST

STRUCTURAL CONT.

- S2.05 PARTIAL FOUNDATION PLAN - EAST
- S2.06 SHELTER FOUNDATION PLAN
- S3.00 OVERALL FRAMING PLAN
- S3.01 PARTIAL ROOF FRAMING PLAN - WEST
- S3.02 PARTIAL ROOF FRAMING PLAN - EAST
- S3.03 PARTIAL ROOF FRAMING PLAN - SHELTER
- S3.04 PARTIAL ROOF FRAMING PLAN
- S4.01 FRAMING ELEVATIONS & DETAILS
- S4.02 FRAMING ELEVATIONS & DETAILS
- S4.03 FRAMING ELEVATIONS & DETAILS
- S5.01 FOUNDATION SECTIONS & DETAILS
- S6.01 FRAMING SECTIONS & DETAILS
- S6.02 FRAMING SECTIONS & DETAILS
- S6.03 FRAMING SECTIONS & DETAILS


MECHANICAL

- M1.00 MECHANICAL LEGEND & ABBREVIATIONS
- M2.00 UNDER FLOOR DEMO PLAN
- M2.10 ABOVE FLOOR DEMO PLAN
- M2.20 MECHANICAL DEMO PLAN
- M2.30 MECHANICAL ROOF DEMO PLAN
- M3.00 UNDER FLOOR PLUMBING PLAN - OVERALL
- M3.10 UNDER FLOOR PLUMBING PLAN - WEST
- M3.20 UNDER FLOOR PLUMBING PLAN - EAST
- M3.30 ABOVE FLOOR PLUMBING PLAN - OVERALL
- M3.40 ABOVE FLOOR PLUMBING PLAN - WEST
- M3.50 ABOVE FLOOR PLUMBING PLAN - EAST
- M3.60 ENLARGED ABOVE FLOOR PLUMBING PLAN
- M4.00 MECHANICAL FLOOR PLAN - OVERALL
- M4.10 MECHANICAL FLOOR PLAN - WEST
- M4.20 MECHANICAL FLOOR PLAN - EAST
- M4.30 MECHANICAL ROOF PLAN - OVERALL
- M4.40 MECHANICAL ROOF PLAN - WEST
- M4.50 MECHANICAL ROOF PLAN - EAST
- M5.00 MECHANICAL SCHEDULES
- M5.10 MECHANICAL SCHEDULES
- M6.00 MECHANICAL DETAILS
- M6.10 MECHANICAL DETAILS
- M7.00 FIRE PROTECTION - OVERALL
- M7.10 FIRE PROTECTION - WEST
- M7.20 FIRE PROTECTION - EAST
- M7.30 FIRE PROTECTION DETAILS
- M8.00 MECHANICAL CONTROLS & SEQUENCES
- M8.01 MECHANICAL CONTROLS & SEQUENCES


ELECTRICAL

- E0.00 ELECTRICAL LEGEND
- E0.10 ELECTRICAL DEMOLITION PLAN
- E2.01 ELECTRICAL LIGHTING PLAN WEST
- E2.02 ELECTRICAL LIGHTING PLAN CENTRAL
- E2.03 ELECTRICAL LIGHTING PLAN EAST
- E2.04 ELECTRICAL LIGHTING DETAILS
- E3.01 ELECTRICAL POWER PLAN WEST
- E3.02 ELECTRICAL POWER PLAN CENTRAL
- E3.03 ELECTRICAL POWER PLAN EAST
- E3.04 ELECTRICAL POWER DETAILS
- E4.01 ELECTRICAL SYSTEMS PLAN WEST
- E4.02 ELECTRICAL SYSTEMS PLAN CENTRAL
- E4.03 ELECTRICAL SYSTEMS PLAN EAST
- E4.04 ELECTRICAL SYSTEMS DETAILS
- E5.01 ELECTRICAL FIRE DIAGRAM
- E5.02 ELECTRICAL PANEL SCHEDULES

SYMBOLS

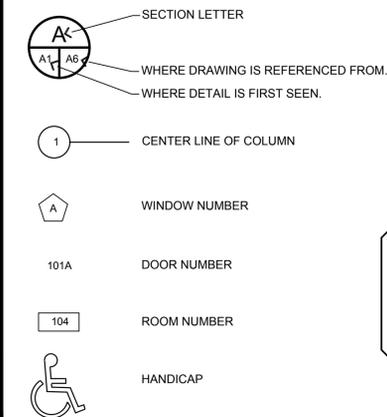

MATERIAL LEGEND

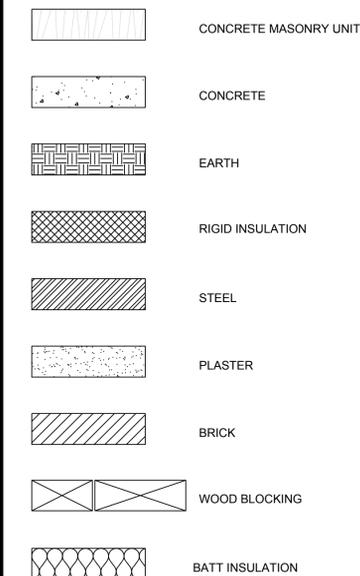

Consultants:

This document contains confidential information. It is an instrument of service and property of the architect. It shall not be used on other projects or for the execution of this project without the Architect's written approval.
Do Not Reproduce

The 2023 New Additions and Renovations for:

Mid America
Technology Center

Wayne, OK 73095

27438 Oklahoma 59

DESIGN ARCHITECTS PLUS



1501 S.W. 104th
Oklahoma City, OK 73159
Phone No. (405)691-9900
Fax. No. (405)691-2080
www.dap-okc.com


Revisions:

Date: 01/06/23
Job #: 0655.0

Sheet No.


G-1

Cover

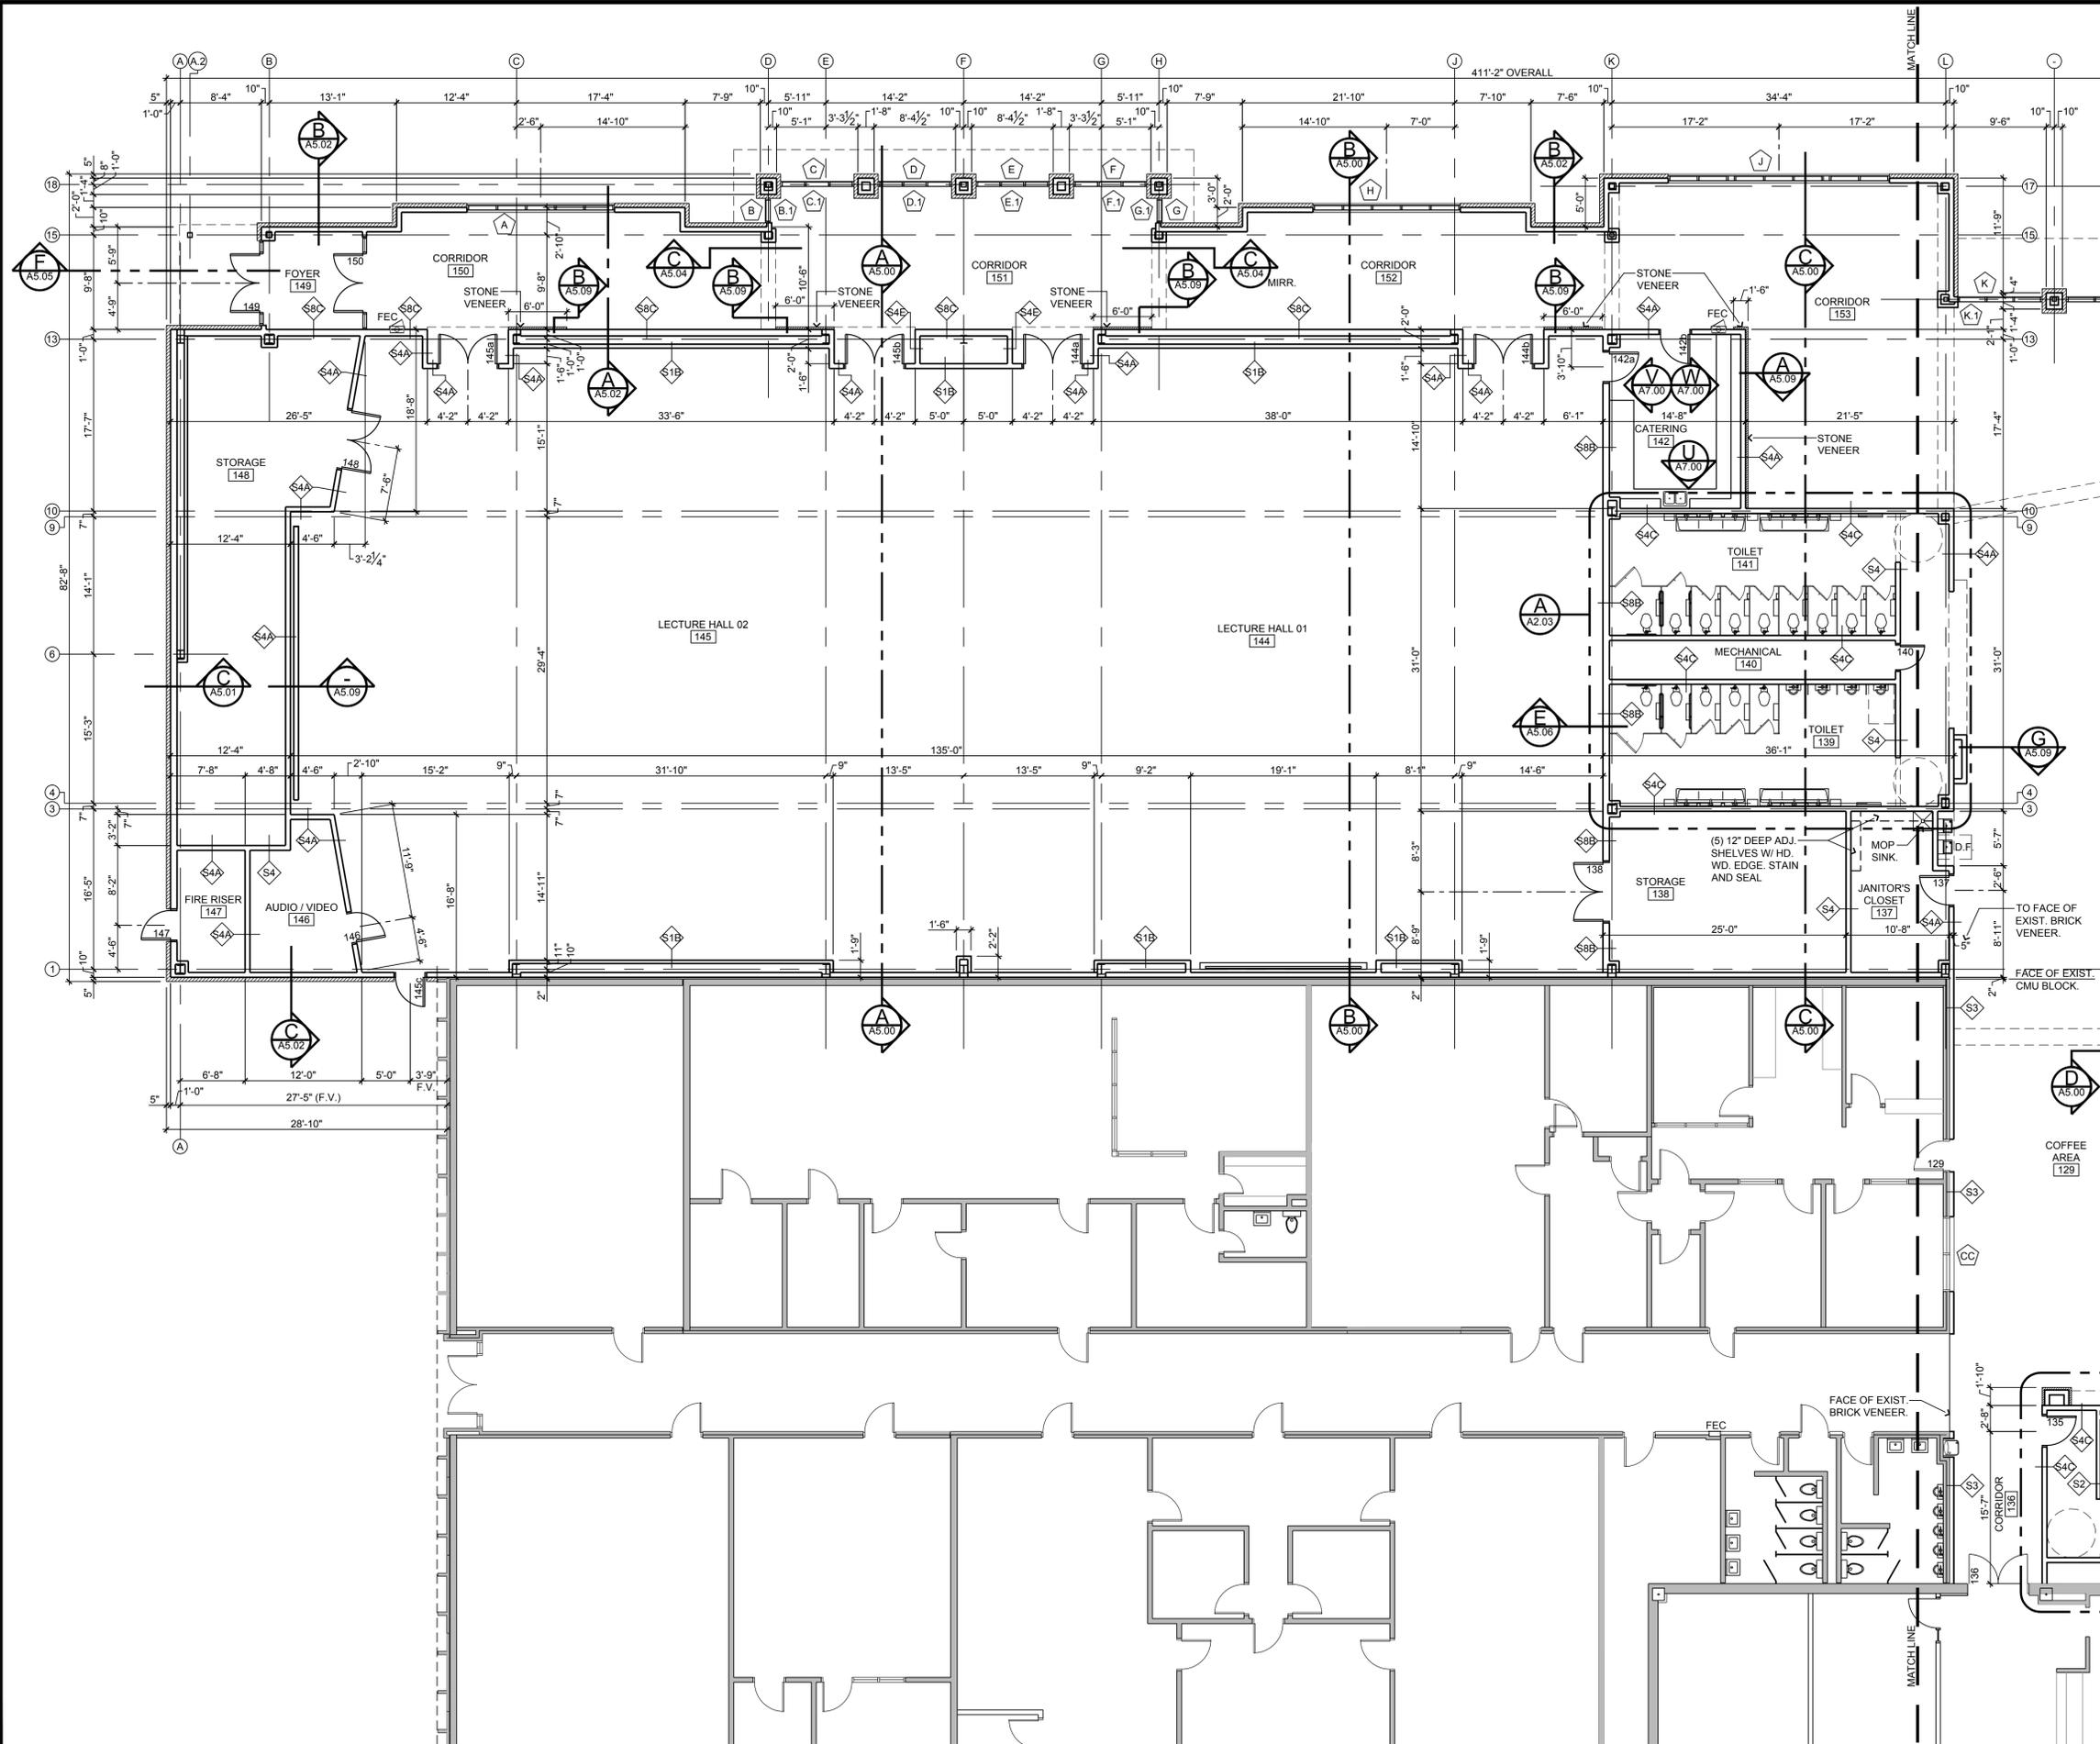

A FLOOR PLAN
 SCALE: 1/8" = 1'-0"
 NORTH

Consultants:

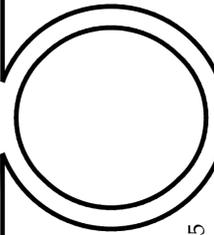


The 2023 New Additions and Renovations for:
Mid America Technology Center
 27438 Oklahoma 59
 Wayne, OK 73095

DESIGN ARCHITECTS PLUS

 1501 S.W. 104th
 Oklahoma City, OK 73159
 Phone No. (405)691-9900
 Fax No. (405)691-2080
 www.dap-okc.com


Revisions:

Date: 01/04/23
 Job #: 0655.0
 Sheet No.
A2.01
 Floor Plan

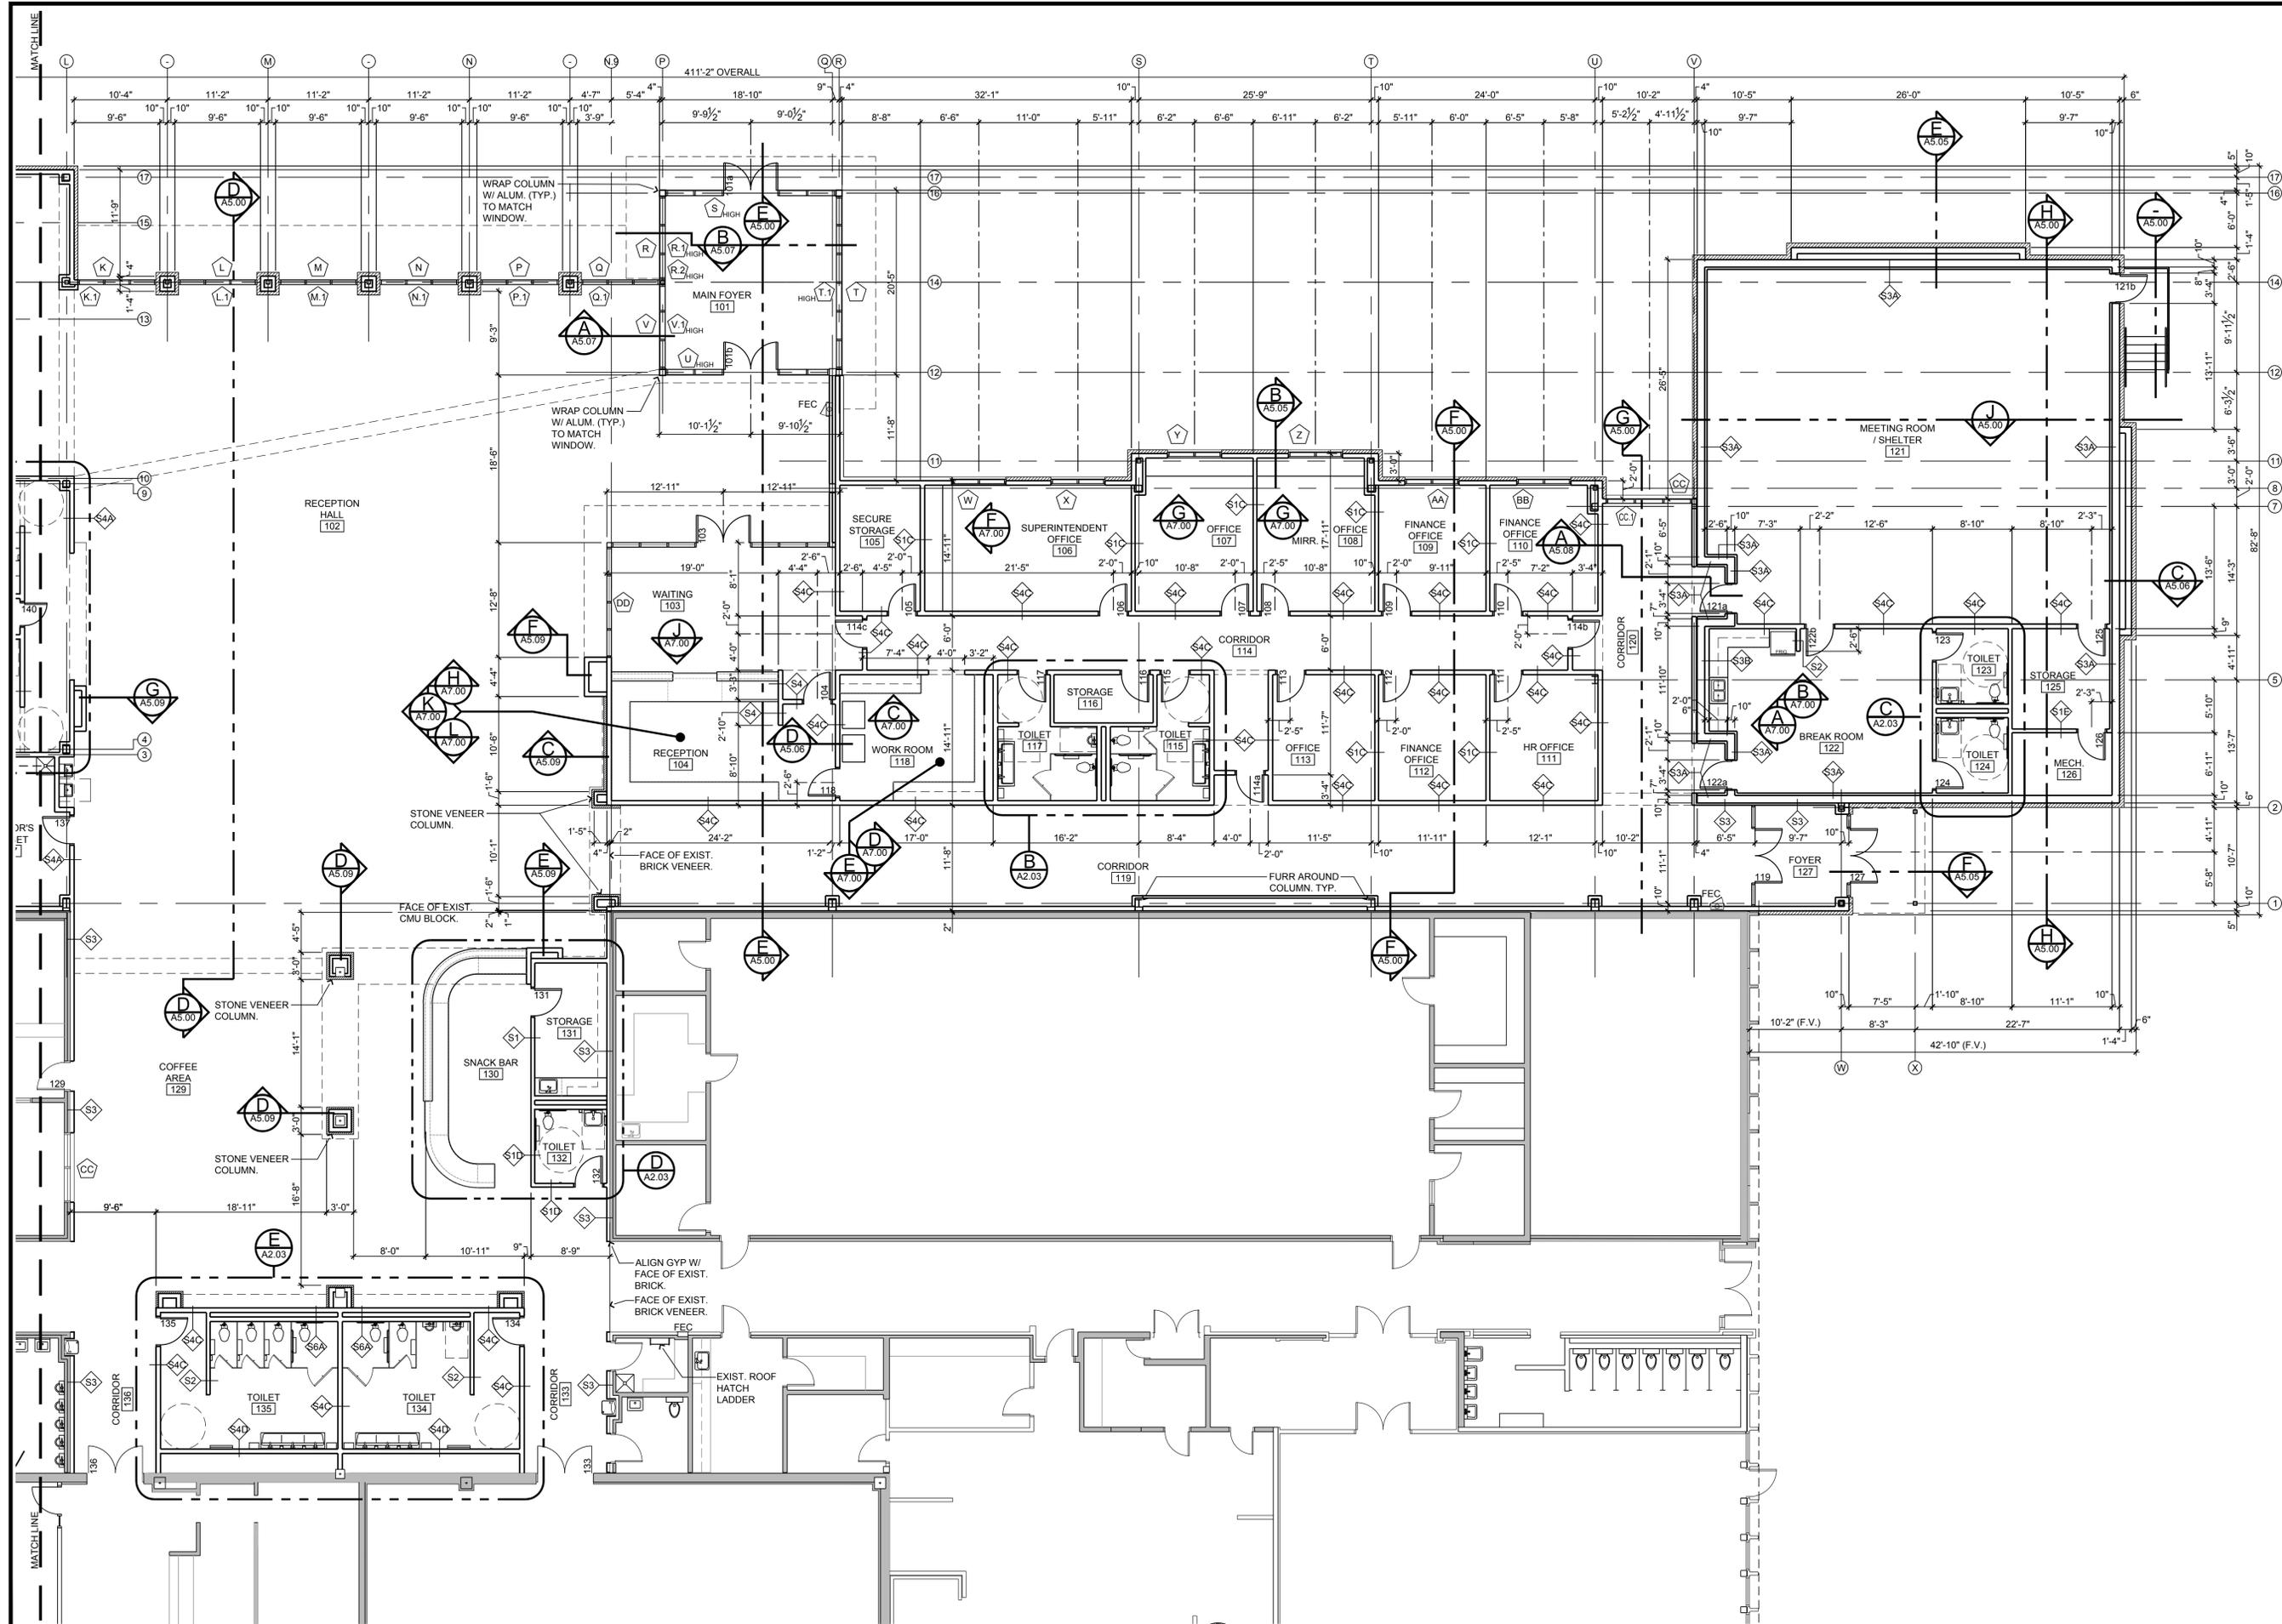

A FLOOR PLAN
 SCALE: 1/8" = 1'-0"
 NORTH

Consultants:

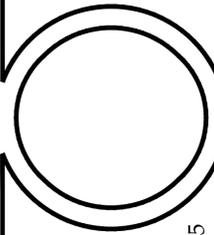

The 2023 New Additions and Renovations for:
Mid America Technology Center
 27438 Oklahoma 59
 Wayne, OK 73095

DESIGN ARCHITECTS PLUS

 1501 S.W. 104th
 Oklahoma City, OK 73159
 Phone No. (405)691-9900
 Fax No. (405)691-2080
 www.dap-okc.com

Revisions:

Date: 01/04/23
 Job #: 0655.0
 Sheet No.
A2.02
 Floor Plan